

INDEX OF SHEETS


SHEET	PLAN SHEET	TITLE
1		TITLE SHEET
2	CD-1	SURVEY AND CONTROL DIAGRAM
3-4	X-1 THRU X-2	TYPICAL SECTIONS
5-7	L-1 THRU L-3	LAYOUT
8	C-1	CONSTRUCTION DETAILS
9	EC-1	EROSION CONTROL
10-11	D-1 THRU D-2	DRAINAGE LAYOUT
12	D-3	DRAINAGE QUANTITIES
13	DM-1	DEMOLITION PLAN
14	DE-1	DETOUR PLAN
15	SPD-1	SIGNING AND PAVEMENT DELINEATION
16	S-1	STRUCTURAL DETAILS
17	DX-1	EID CROSSING
18	RW-1	RETAINING WALL NO. 1

COUNTY OF EL DORADO, CA
 COMMUNITY DEVELOPMENT AGENCY
 TRANSPORTATION DIVISION


PROJECT PLANS FOR THE CONSTRUCTION OF
 BLAIR ROAD AT EID CANAL
 BRIDGE REPLACEMENT

IN THE COUNTY OF EL DORADO, DISTRICT 5
 ON BLAIR ROAD, 0.54± MILES NORTH OF THE PONY EXPRESS/BLAIR RD INTERSECTION


To be supplemented with Standard Plans and Specifications dated 2010, including the revised Standard Specifications, of the California Department of Transportation, unless otherwise noted.

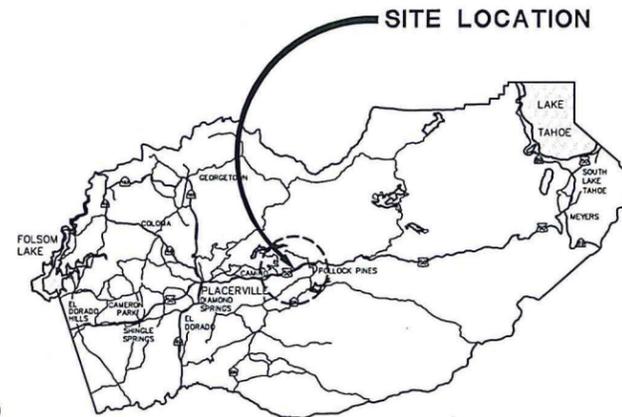

VICINITY MAP
 COUNTY OF EL DORADO

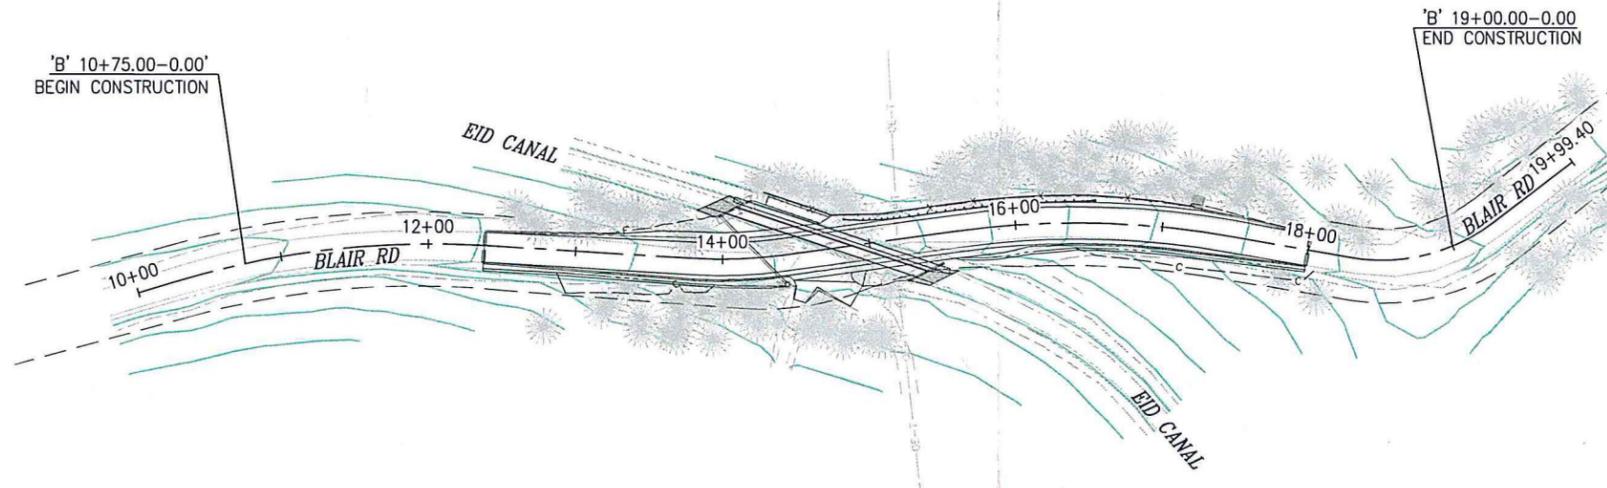

SITE PLAN
 SCALE: 1"=60'

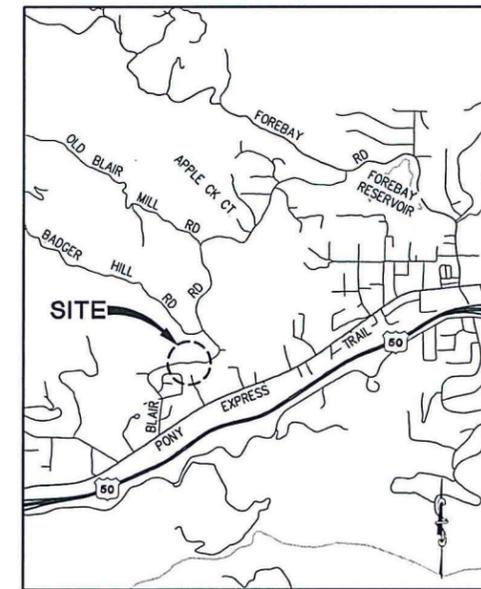

LOCATION MAP
 NOT TO SCALE

BOARD OF SUPERVISORS

I	RON MIKULACO
II	SHIVA FRENTZEN
III	BRIAN VEERKAMP
IV	MICHAEL RANALLI
V	SUE NOVASEL

COUNTY OF EL DORADO
 COMMUNITY DEVELOPMENT AGENCY
 TRANSPORTATION DIVISION

(530) 621-5900
 2850 FAIRLANE CT
 PLACERVILLE, CA 95667

ADOPTED AND APPROVED: [Signature] DATE: 7/19/16

RON MIKULACO, CHAIR, EL DORADO COUNTY BOARD OF SUPERVISORS

APPROVED BY: [Signature] DATE: 7/14/16

STEVEN K. ROBERTS, DIRECTOR, COMMUNITY DEVELOPMENT AGENCY

TONY V. JAMES, P.E., J.S. 45236, DEPUTY DIRECTOR, ENGINEERING

ABBREVIATIONS

- MGS — MIDWEST GUARDRAIL SYSTEM
- RCPE — REINFORCED CONCRETE PIPE ELLIPTICAL

CONTRACTOR'S LICENSE CLASSIFICATION: Bidders shall be properly licensed to perform the Work pursuant to the State Contractor's License Act (Business and Professions Code section 7000 et seq.) and shall possess a CLASS A LICENSE or equivalent combination of Classes required by the categories and type of Work included in the Contract Documents and Plans. Failure of the successful Bidder to obtain proper and adequate licensing at the time bids are submitted shall constitute a failure to execute the Contract, and forfeiture under that section.

REVISIONS

MARK	DATE	BY



FEDERAL AID PROJECT
 BRLO 5925(143)



Submitted by: Frank W. Whitmore III
 CIVIL ENGINEER
 STATE OF CALIFORNIA NO. [blank]
 DATE: 07/01/16

PW NO. 15-31111 PROJECT NO. 77119

BLAIR ROAD AT EID CANAL
 BRIDGE REPLACEMENT

TITLE SHEET

SHEET 1 OF 18